


Appendix C

Preliminary Civil Site Plan

LEGEND


- x— CHAIN LINK FENCE
- - - RETENTION POND
- ROADS

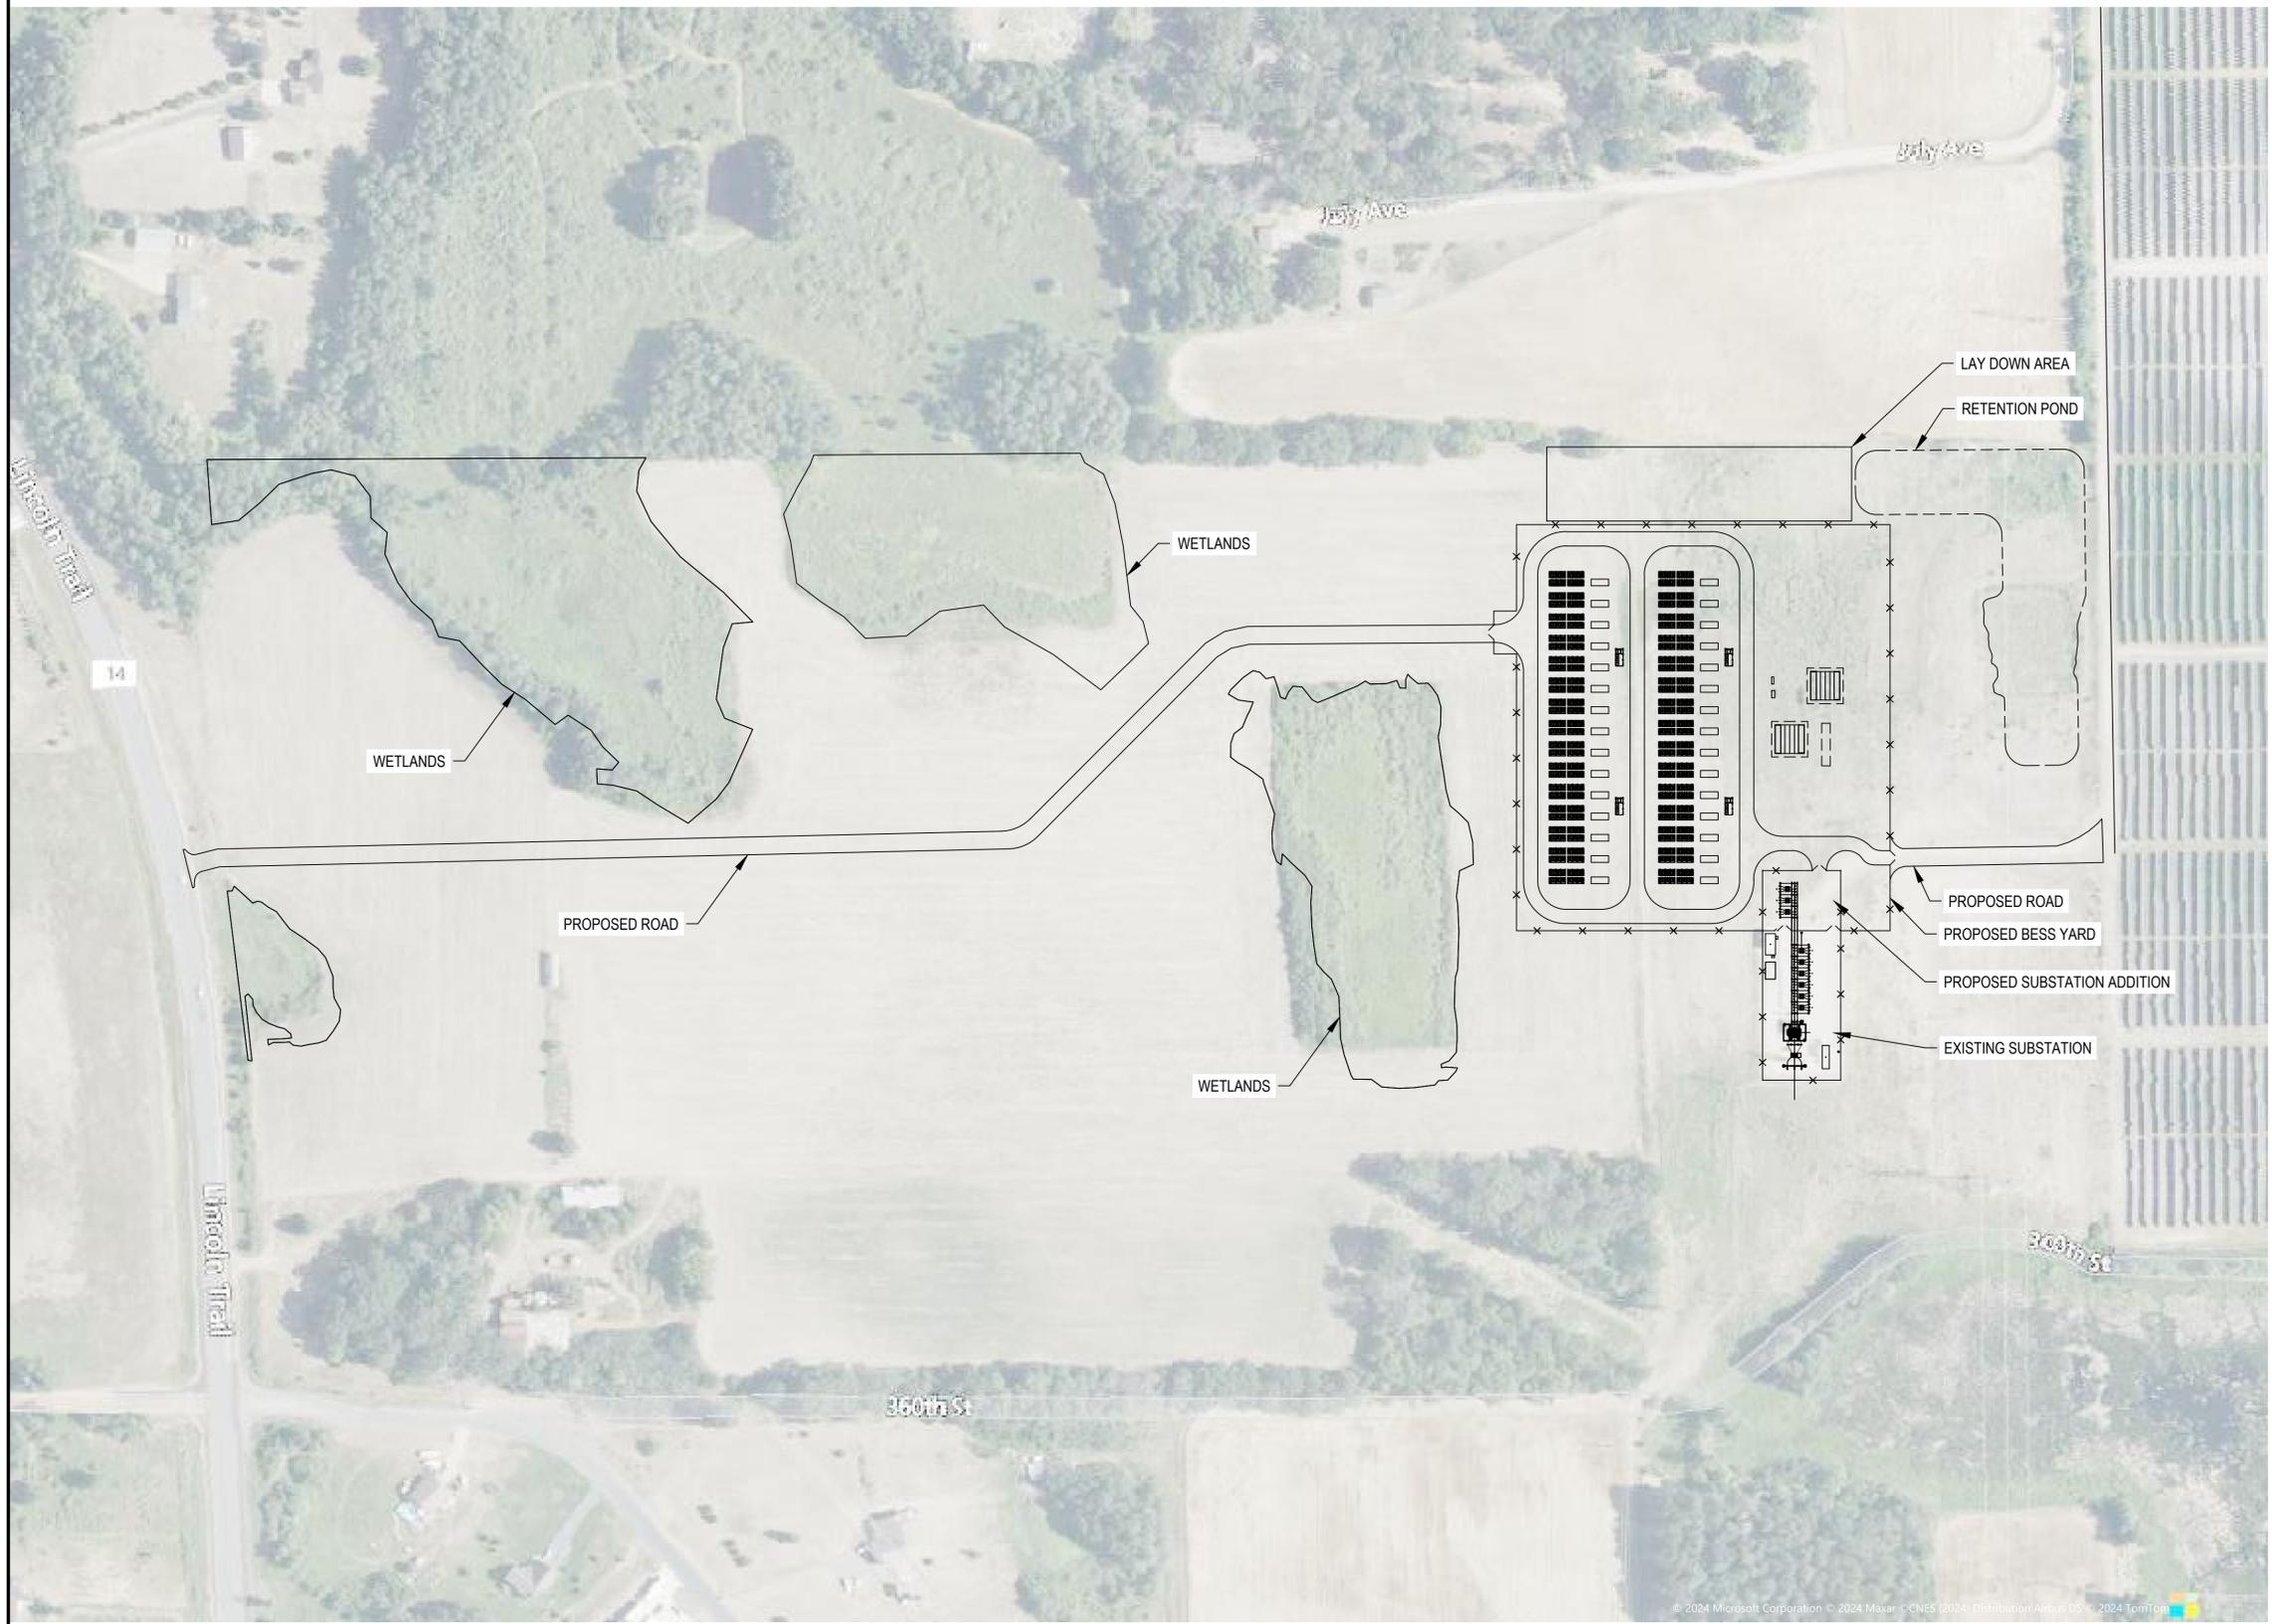

REV	DATE	DWN	CHKD	APVD	DESCRIPTION
CEG CONSULTING ENGINEERS GROUP LAKEVILLE, MINNESOTA					
NORTH STAR BESS BATTERY ENERGY STORAGE SYSTEM PLOT PLAN - SUB & BESS ARIAL - COLLECTION SYSTEM					
SCALE: 1/128" = 1'-0"					PROJECT: CEGDESH46
DRAWN: JMKB					DWG. NO.
DATE: 11/20/24					NS-300PP-RA

LEGEND

- x— CHAIN LINK FENCE
- BASIN
- - - RETENTION POND
- ROADS
- COLLECTION CIRCUIT 1
- COLLECTION CIRCUIT 2
- COLLECTION CIRCUIT 3
- COLLECTION CIRCUIT 4
- - - PA AUXILIARY POWER FEEDER

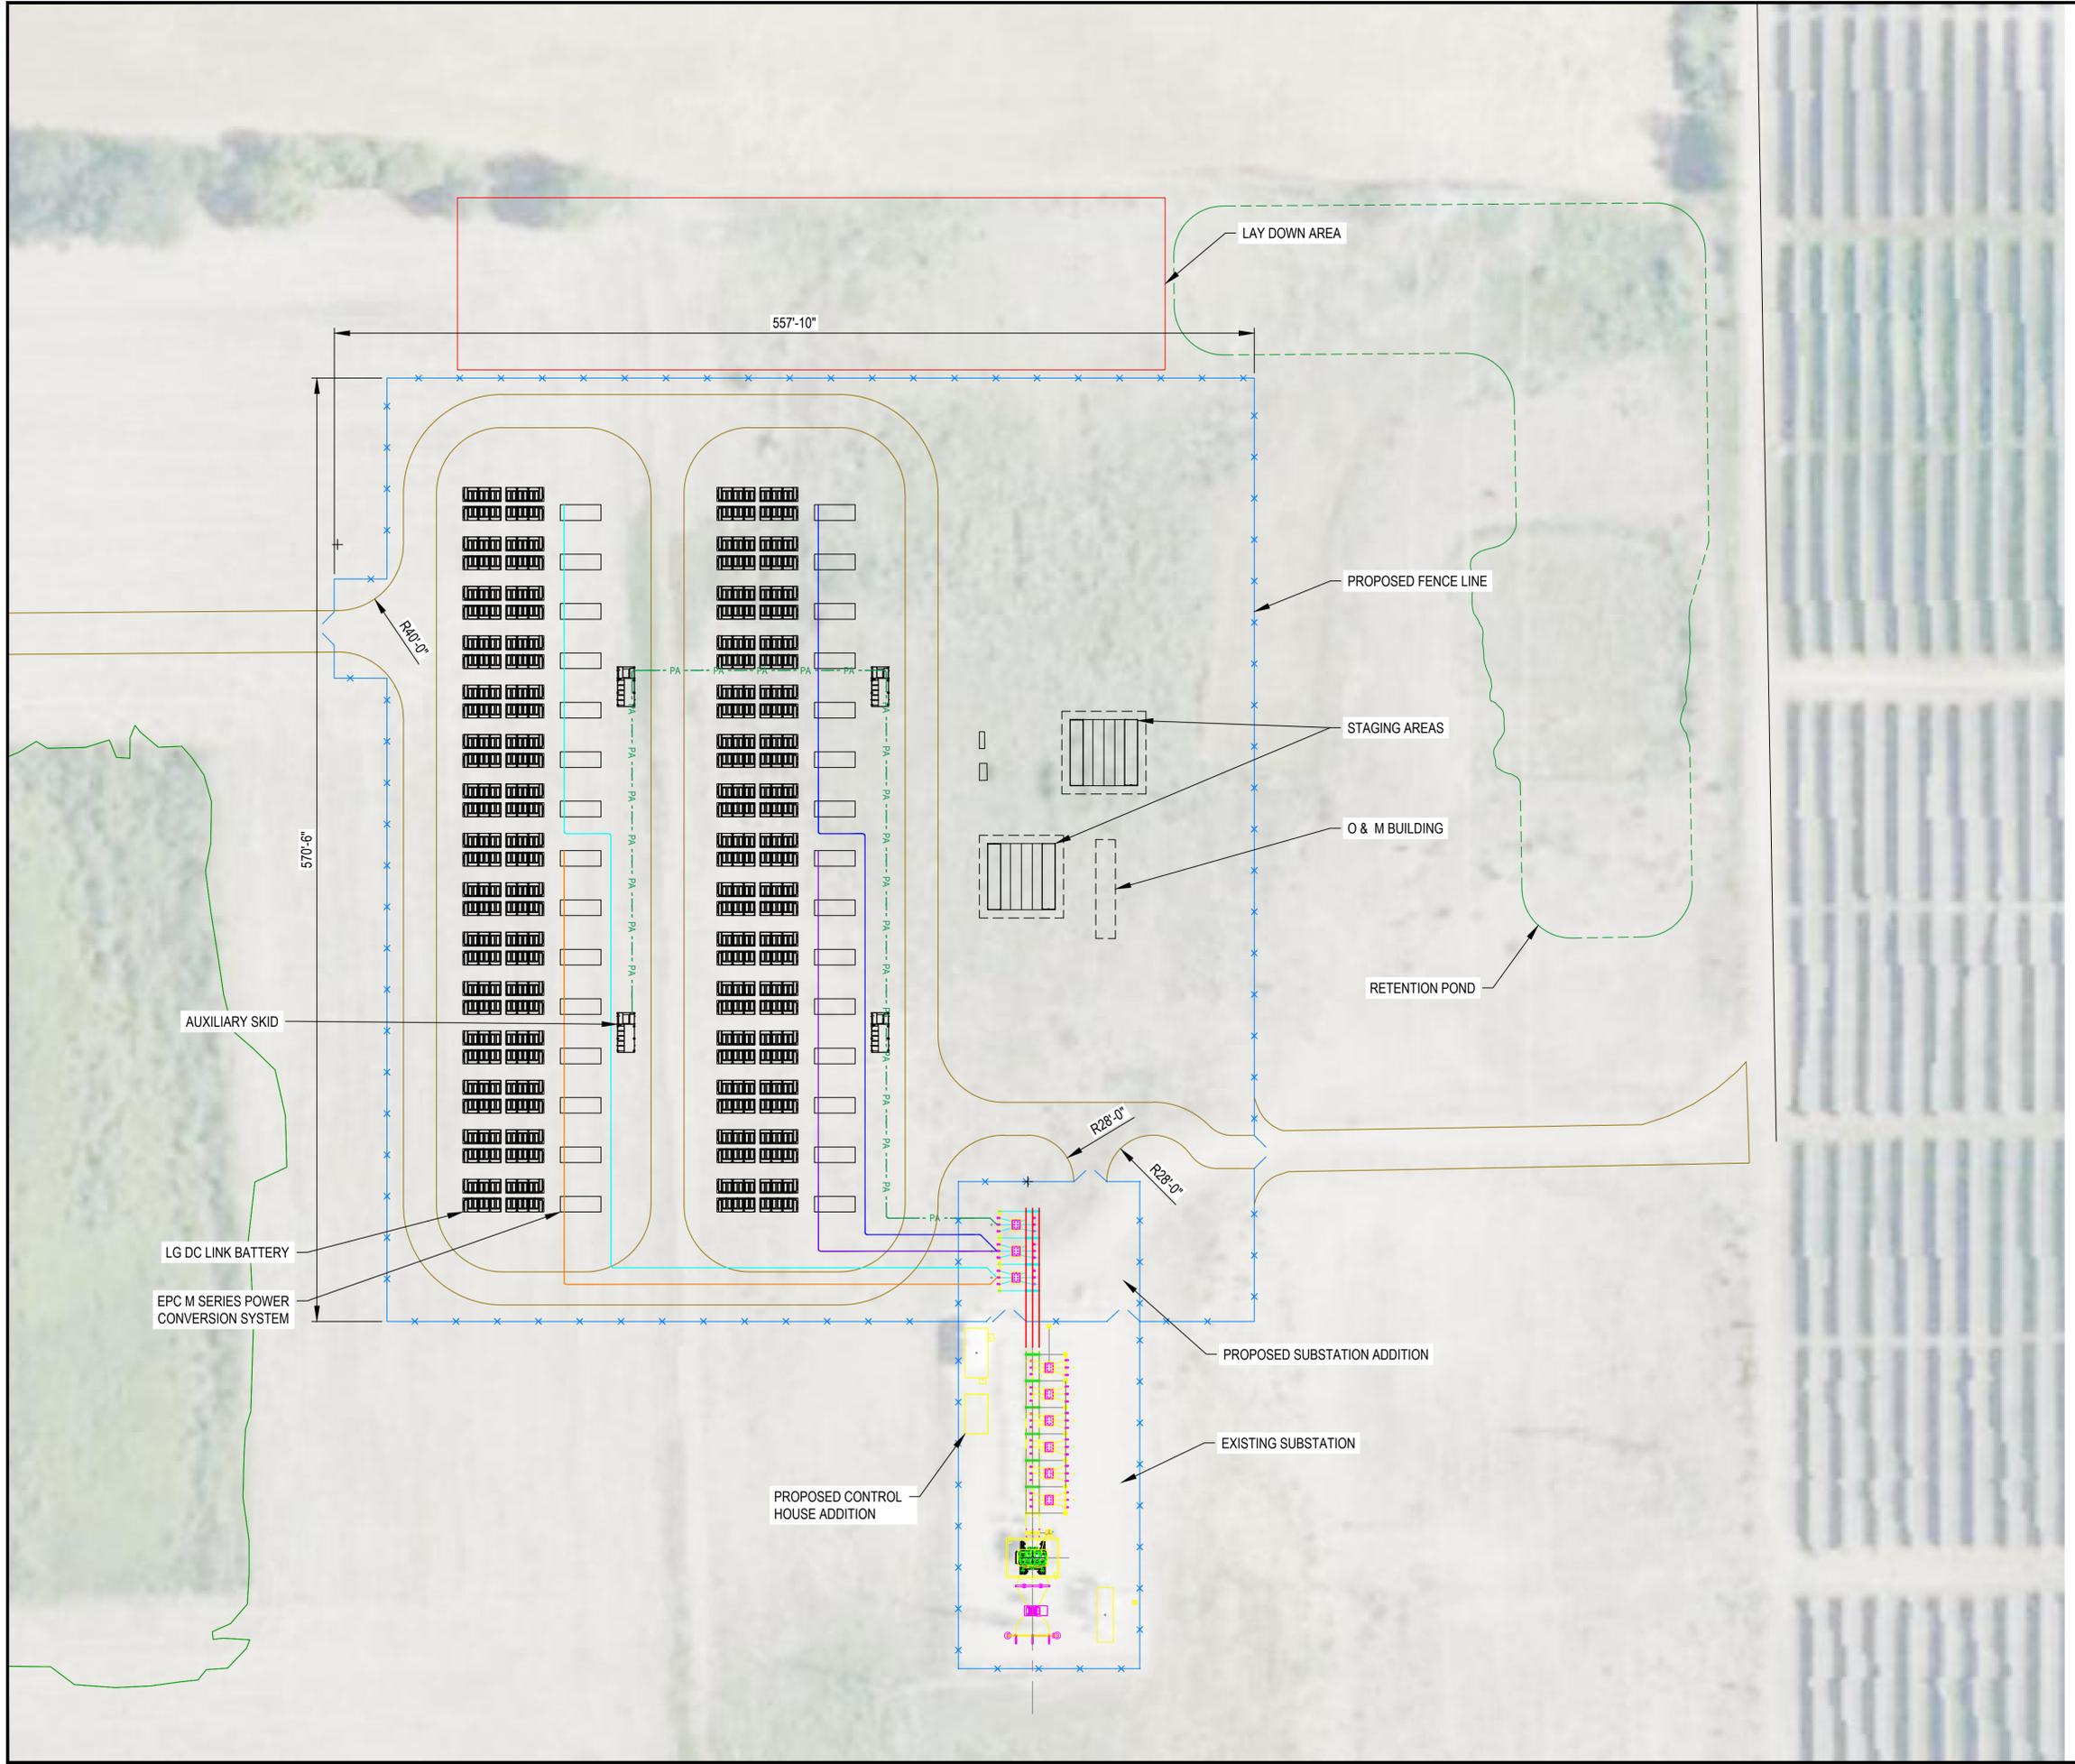

REV	DATE	DWN	CHKD	APVD	DESCRIPTION
<div style="display: flex; justify-content: space-between; align-items: center;"> <div style="font-size: 2em; font-weight: bold; letter-spacing: 0.5em;">CEG</div> <div style="text-align: right;"> <p>CONSULTING ENGINEERS GROUP LAKEVILLE, MINNESOTA</p> <p>NORTH STAR BESS BATTERY ENERGY STORAGE SYSTEM PLOT PLAN - SUB & BESS ARIAL - COLLECTION SYSTEM</p> </div> </div>					
SCALE: 1" = 50'-0"					PROJECT: CEGDESH46
DRAWN: JMKB					DWG. NO.
DATE: 11/20/24					NS-304PP-RA